



314 EXCHANGE ALLEY
PETERSBURG, VA 23804
804.861.1200 P
804.861.1253 F

All ideas, designs, arrangements and plans indicated or represented by this drawing are property of ENTEROS DESIGN, PC; created, evolved and developed for the sole use of this project. These ideas, design arrangements and/or plans shall not be used by or disclosed to any person, firm or corporation for any purpose without written permission from ENTEROS DESIGN, PC. Written dimensions on these drawings shall have precedence over scaled dimensions. Contractors shall verify and be responsible for all dimensions and conditions on the job. The Architect must be notified of any variations from the dimensions and conditions shown on these drawings.
c. 2015 ENTEROS DESIGN, PC

WILLIAMSON ROAD LIBRARY
3837 Williamson Road,
Roanoke, VA 24012


CONSTRUCTION DOCUMENTS

MECHANICAL DDC CONTROLS

PROJ. NO.: 156003 DRAWN BY: Author
05/05/16

REVISIONS


| # | Date |
|---|----------|
| 2 | 05.06.16 |

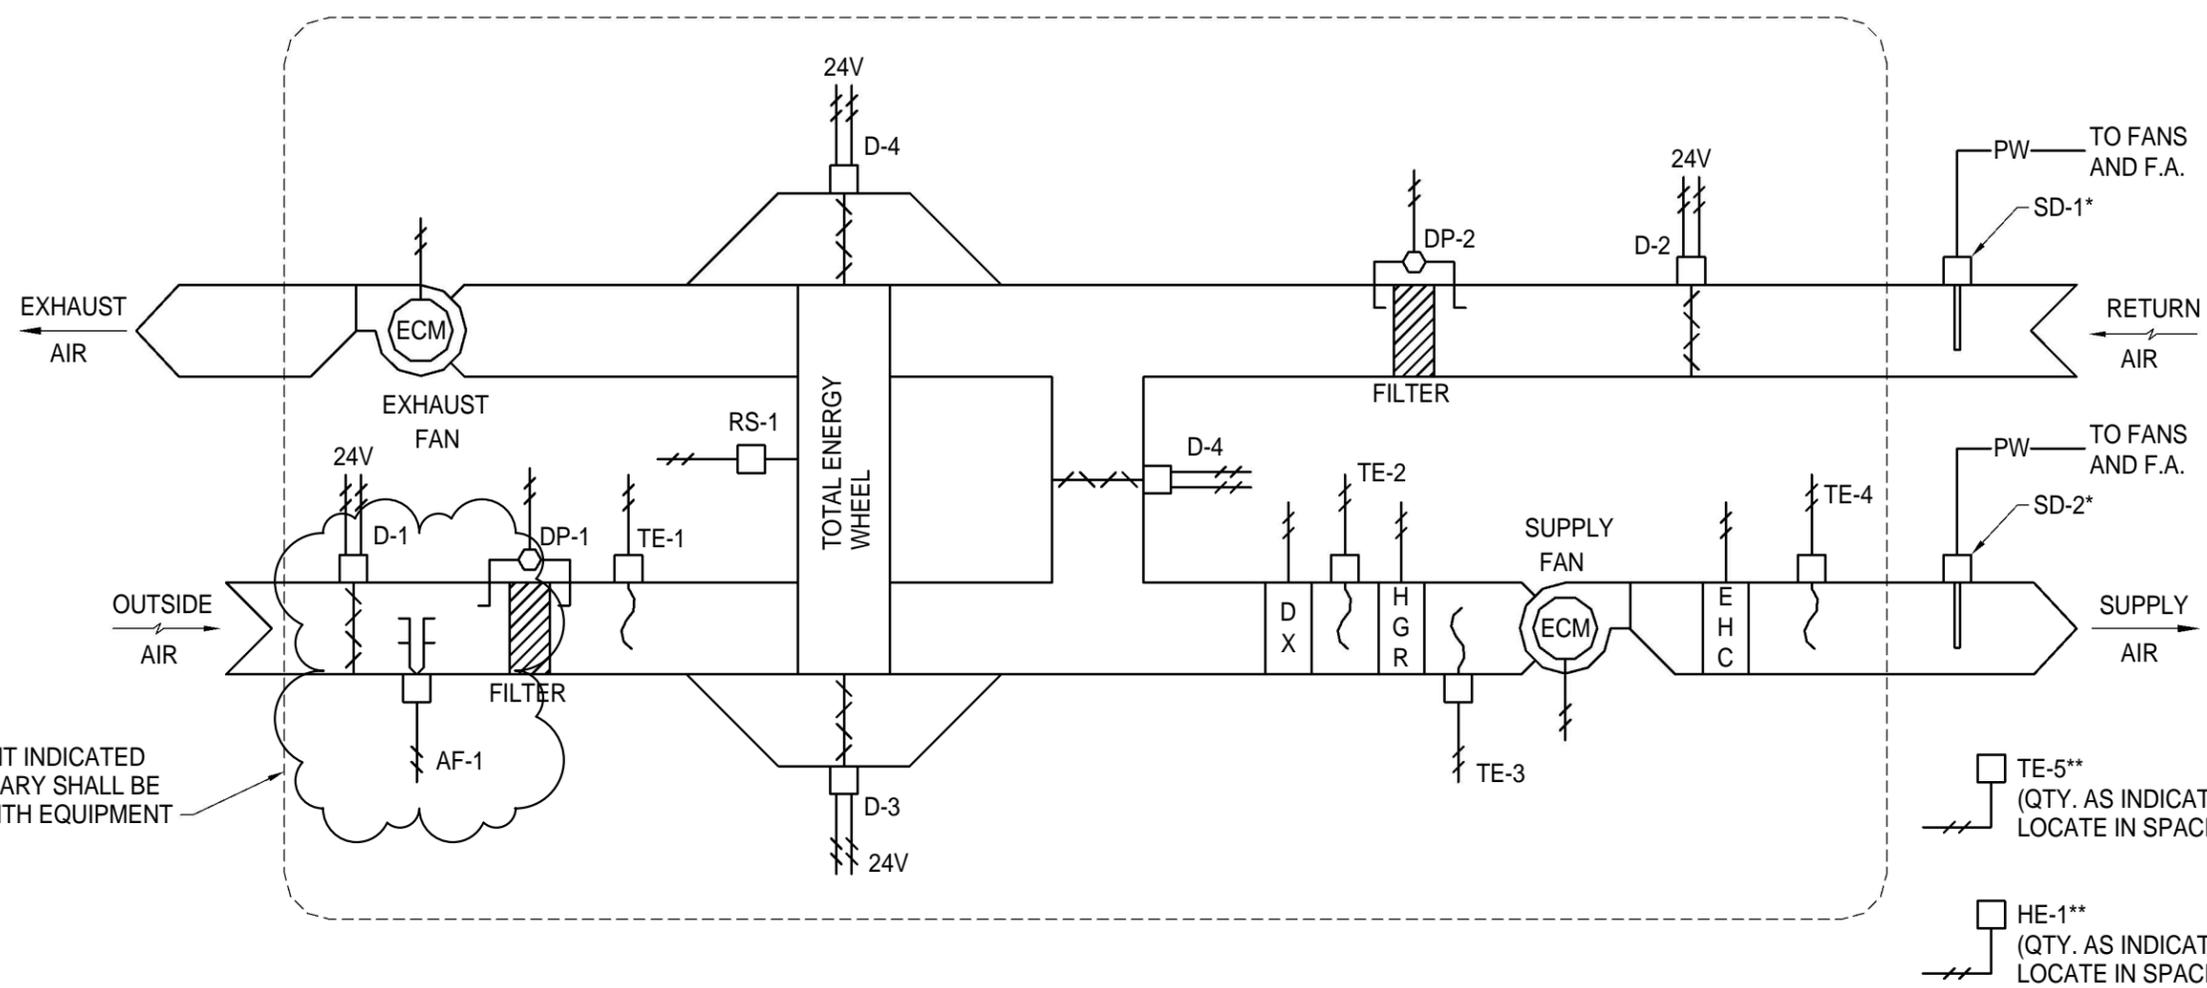

ALL EQUIPMENT INDICATED INSIDE BOUNDARY SHALL BE FURNISHED WITH EQUIPMENT

TE-5**
(QTY. AS INDICATED ON PLANS, LOCATE IN SPACE, REFER TO PLANS)

HE-1**
(QTY. AS INDICATED ON PLANS, LOCATE IN SPACE, REFER TO PLANS)

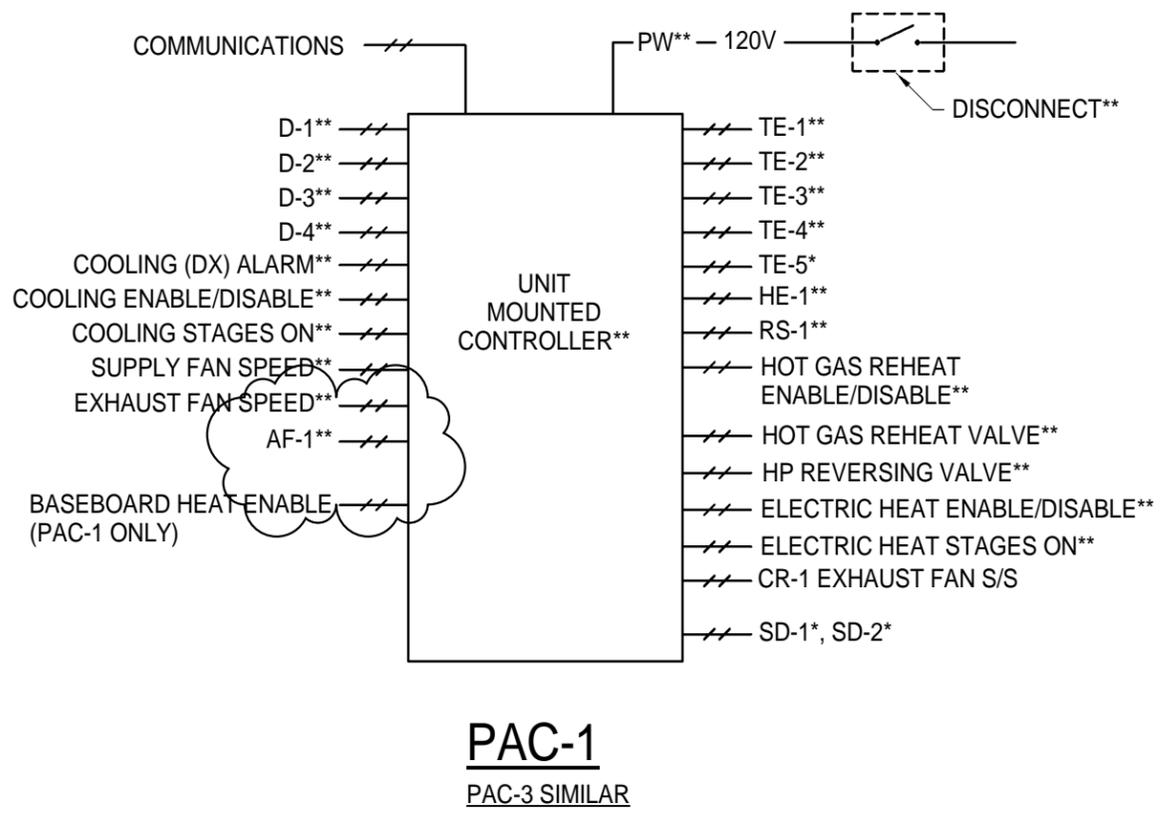

SUPPLEMENT TO M2.01

4932 FRONTAGE ROAD NW
ROANOKE, VIRGINIA 24019
(540) 265-4444
15130